



not be reproduced, copied, loaned, exhibited, or used in any other way, except by written consent from PARSONS to the borrower.

This document and the design it covers are the property of PARSONS. They are loaned only with the borrower's expressed written agreement that they will

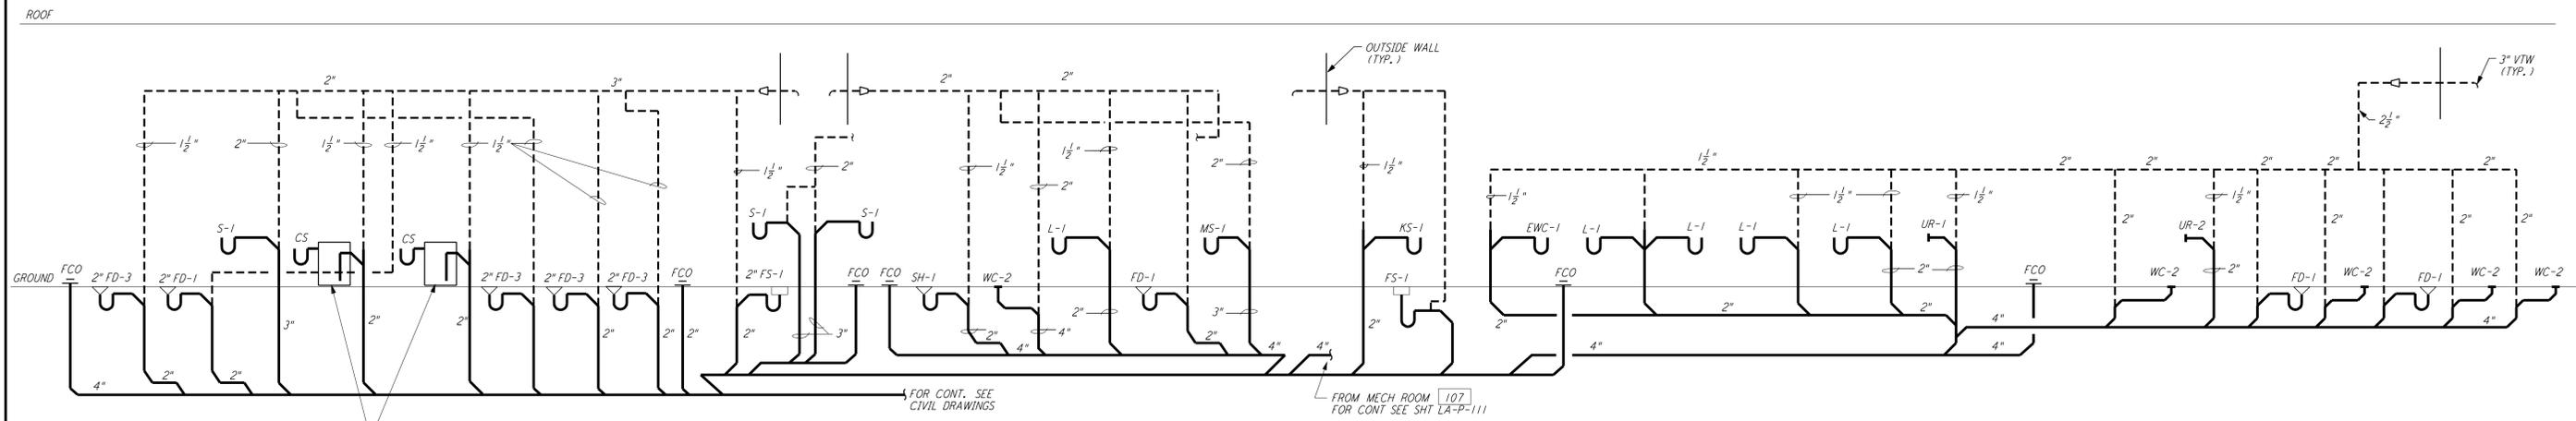

WASTE AND VENT RISER DIAGRAM

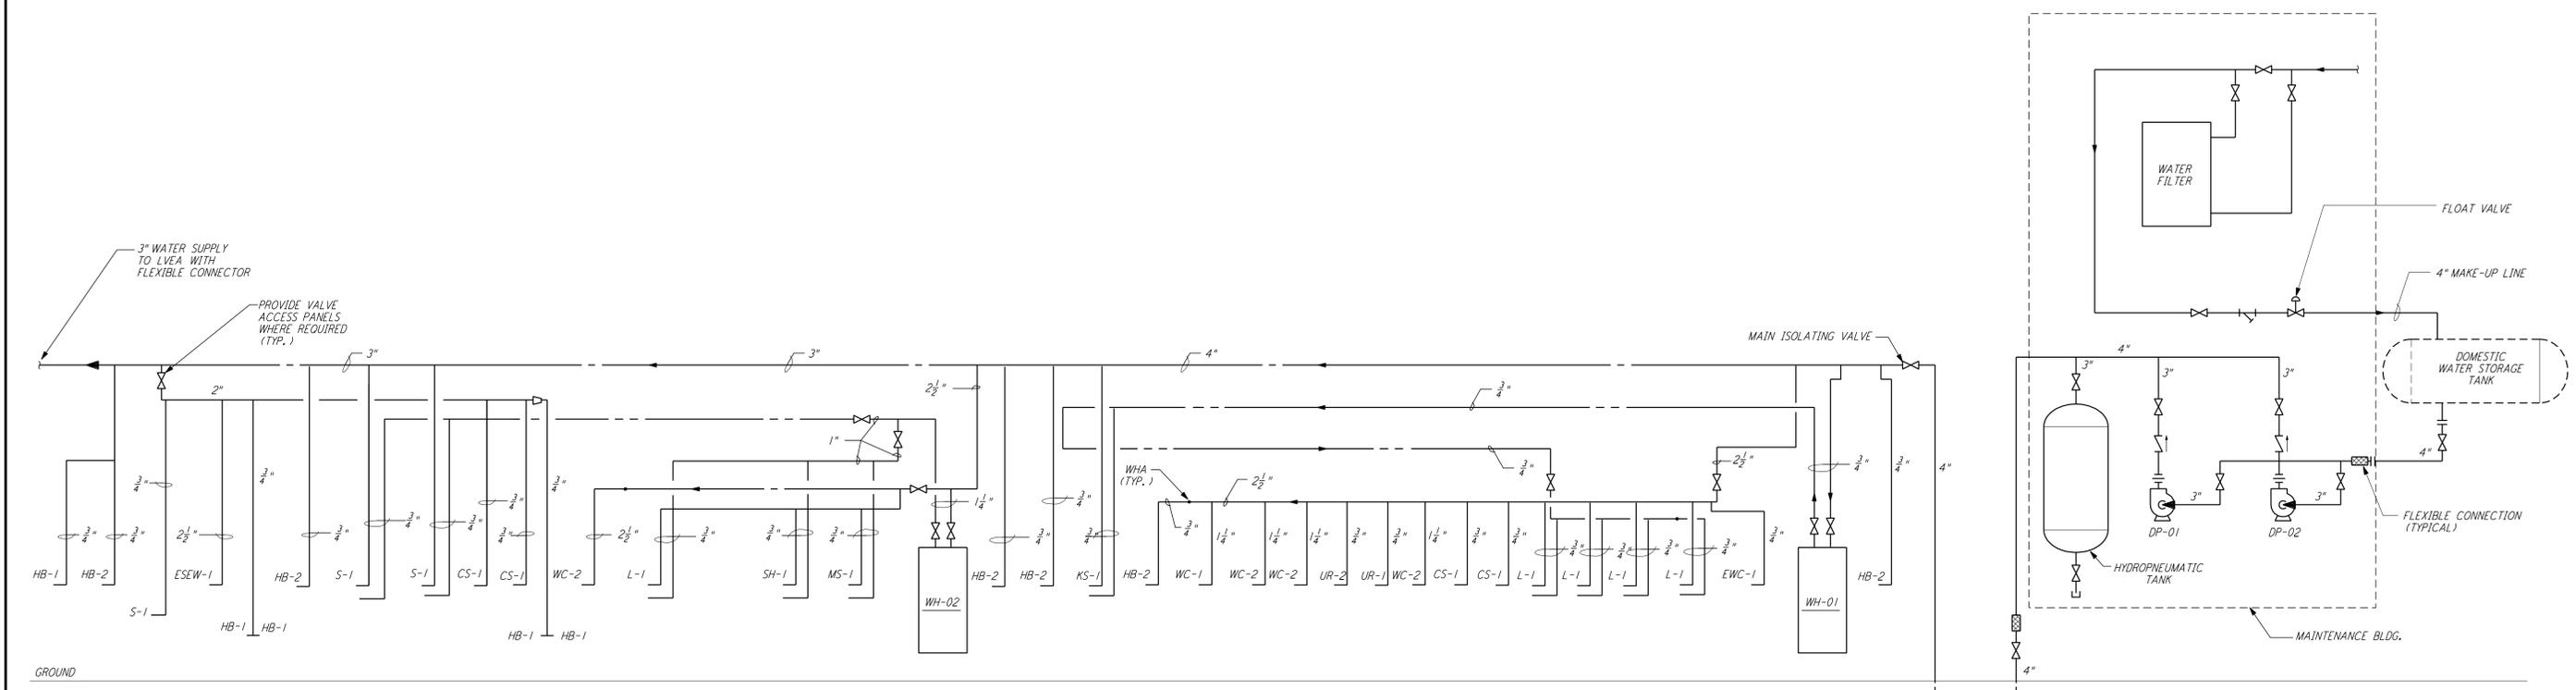

HOT AND COLD WATER RISER DIAGRAM

NO.	DATE	BY	CHKD	ENGR	PROJ	DESCRIPTION
2	8-7-98	DJB				ISSUED FOR AS-BUILT
1	3-20-97	WJK	AA	AA	TDM	REVISED PLUMBING RISER DIAGRAMS

ISSUED FOR CONSTRUCTION		
DRAWN	DG	11-15-96
CHECKED	ME	10-25-96
ENGINEER	AA	10-25-96
PROJ	TDM	11-15-96

AS-BUILT DRAWINGS

PARSONS
 100 WEST WALNUT STREET
 PASADENA, CALIFORNIA

LIGO
 CALIFORNIA INSTITUTE OF TECHNOLOGY
 MASSACHUSETTS INSTITUTE OF TECHNOLOGY

LIGO-D961051-02-O

LASER INTERFEROMETER
 GRAVITATIONAL-WAVE OBSERVATORY
 SITE NO. 2 - LIVINGSTON, LOUISIANA

TITLE	SCALE	CONTRACT NUMBER	PROJECT NUMBER
PLUMBING CORNER STATION RISER DIAGRAM	NONE	PP150969	8094
SHEET NUMBER		REVISIONS	
LA-P-131		2	

Wed Oct 7 14:23:48 1998 c:\p1\site2\mu\lap131.dwg 1:00LAF.BDR